
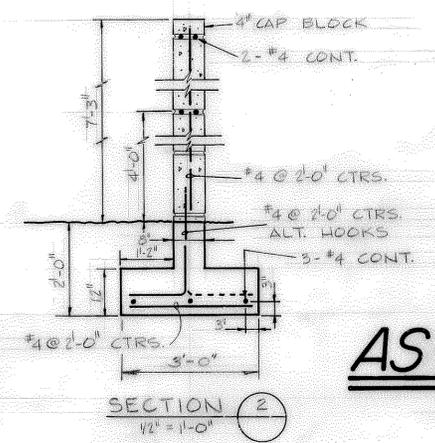
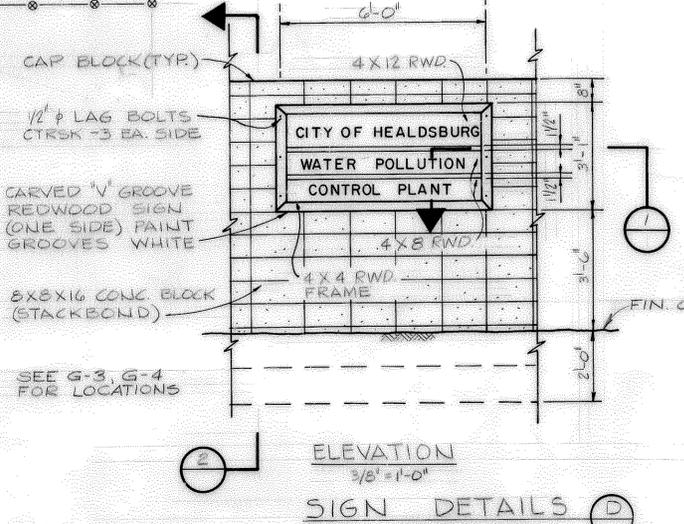
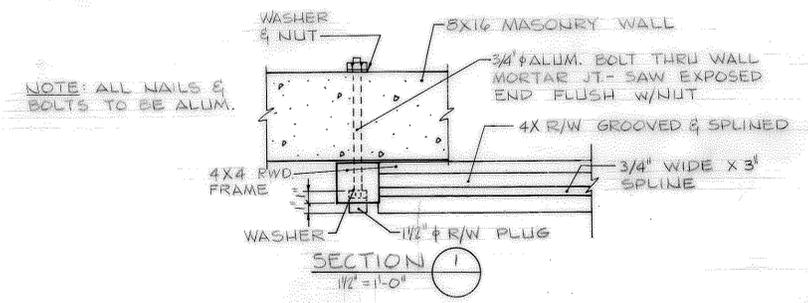
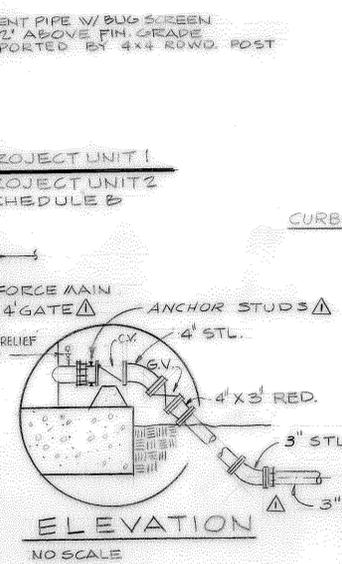
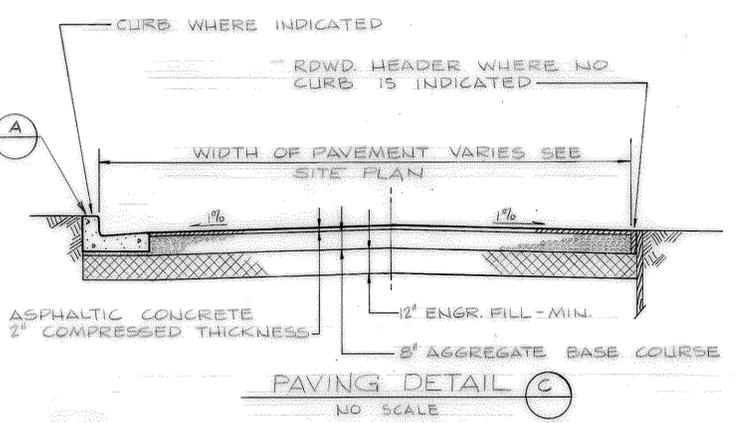
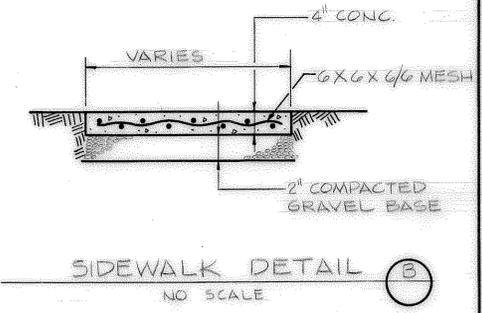
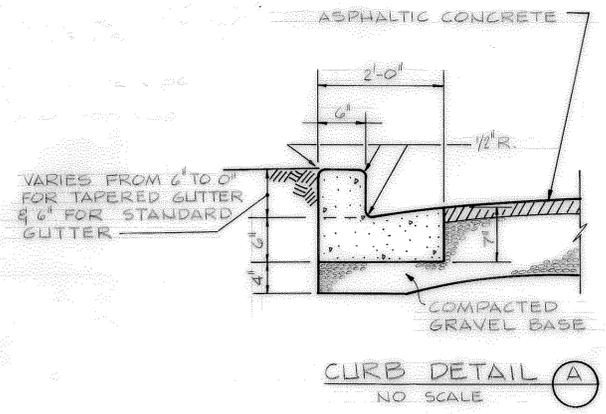


NOTE: DUMMY JOINT EVERY 4 FEET, FILL JOINT WITH BOND BREAKER EVERY 20 FEET, EXCEPT AS OTHERWISE DIRECTED.

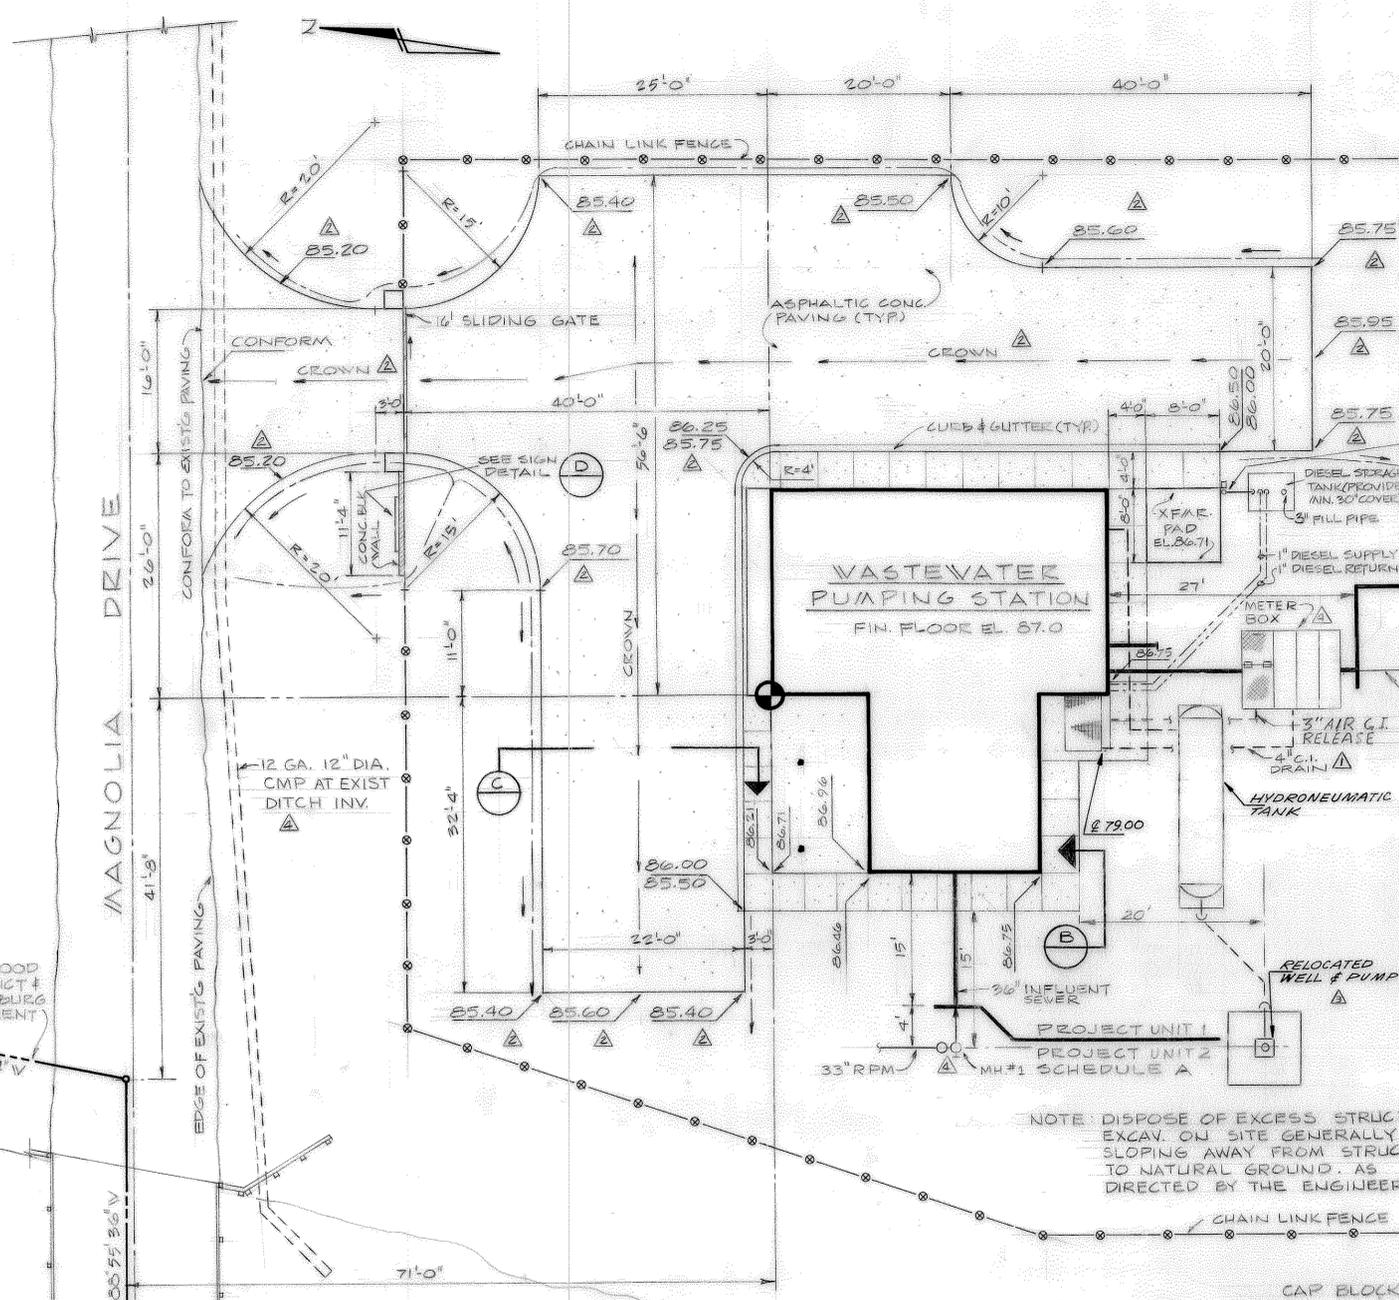

NOTE: DISPOSE OF EXCESS STRUCT. EXCAV. ON SITE GENERALLY SLOPING AWAY FROM STRUCT. TO NATURAL GROUND. AS DIRECTED BY THE ENGINEER.

SITE PLAN
1" = 10'-0"

AS BUILT

RE 4/72	BY	DATE
CHANGE ORDER NO. 2	RE 9/71	
REVISED DRAINAGE	RC 2/71	
ADDENDUM NO. 3	SM 5/70	
NO.	REVISION	

YODER/ORLOB ASSOCIATES
CONSULTING ENGINEERS
WALNUT CREEK, CALIFORNIA

DESIGNED M.E.B.
DRAWN D.R.L. CHECKED E.M.

JOB NO. 6305.2
DATE MARCH-1970

CITY OF HEALDSBURG, SONOMA COUNTY, CALIFORNIA
APPROVED
Project Engineer
R.P.E. CIVIL # 70225
For Yoder/Orlob Associates

WATER POLLUTION CONTROL FACILITIES-1970
PROJECT UNIT 1

WASTEWATER PUMP STATION
SITE PLAN, PAVING, & DETAILS

DRAWING 3 GENERAL

FILE No. D.